

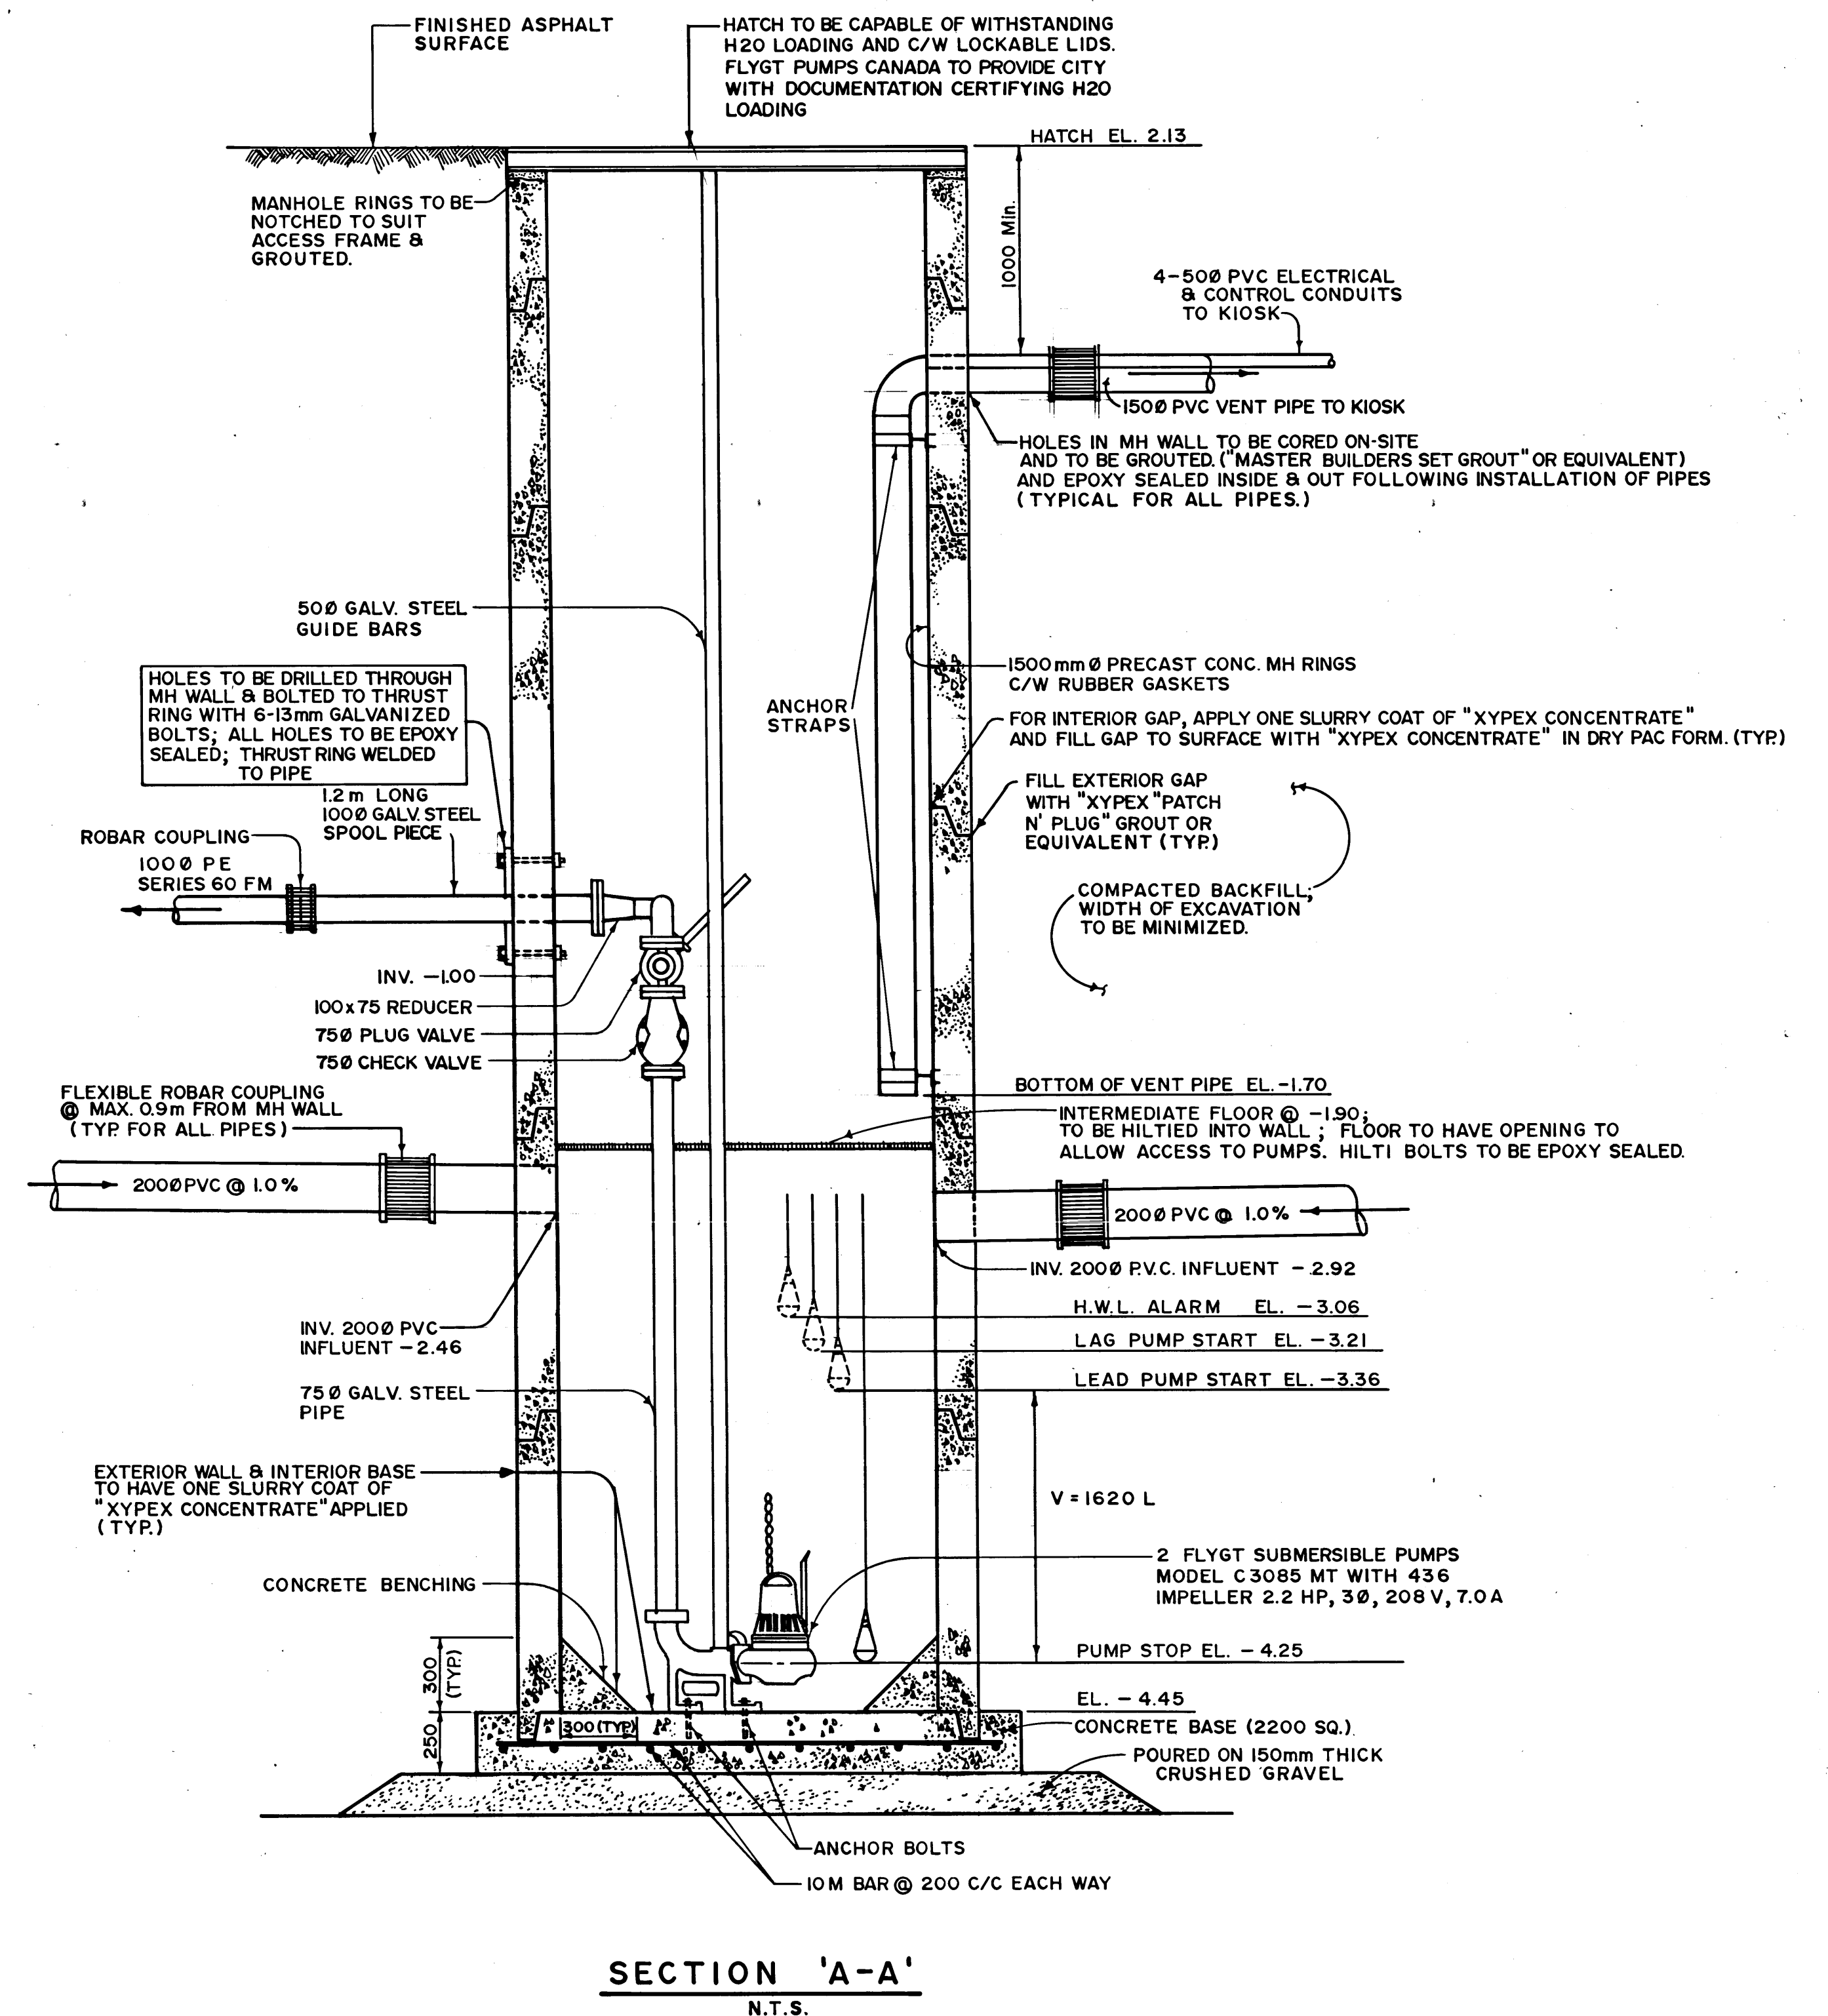
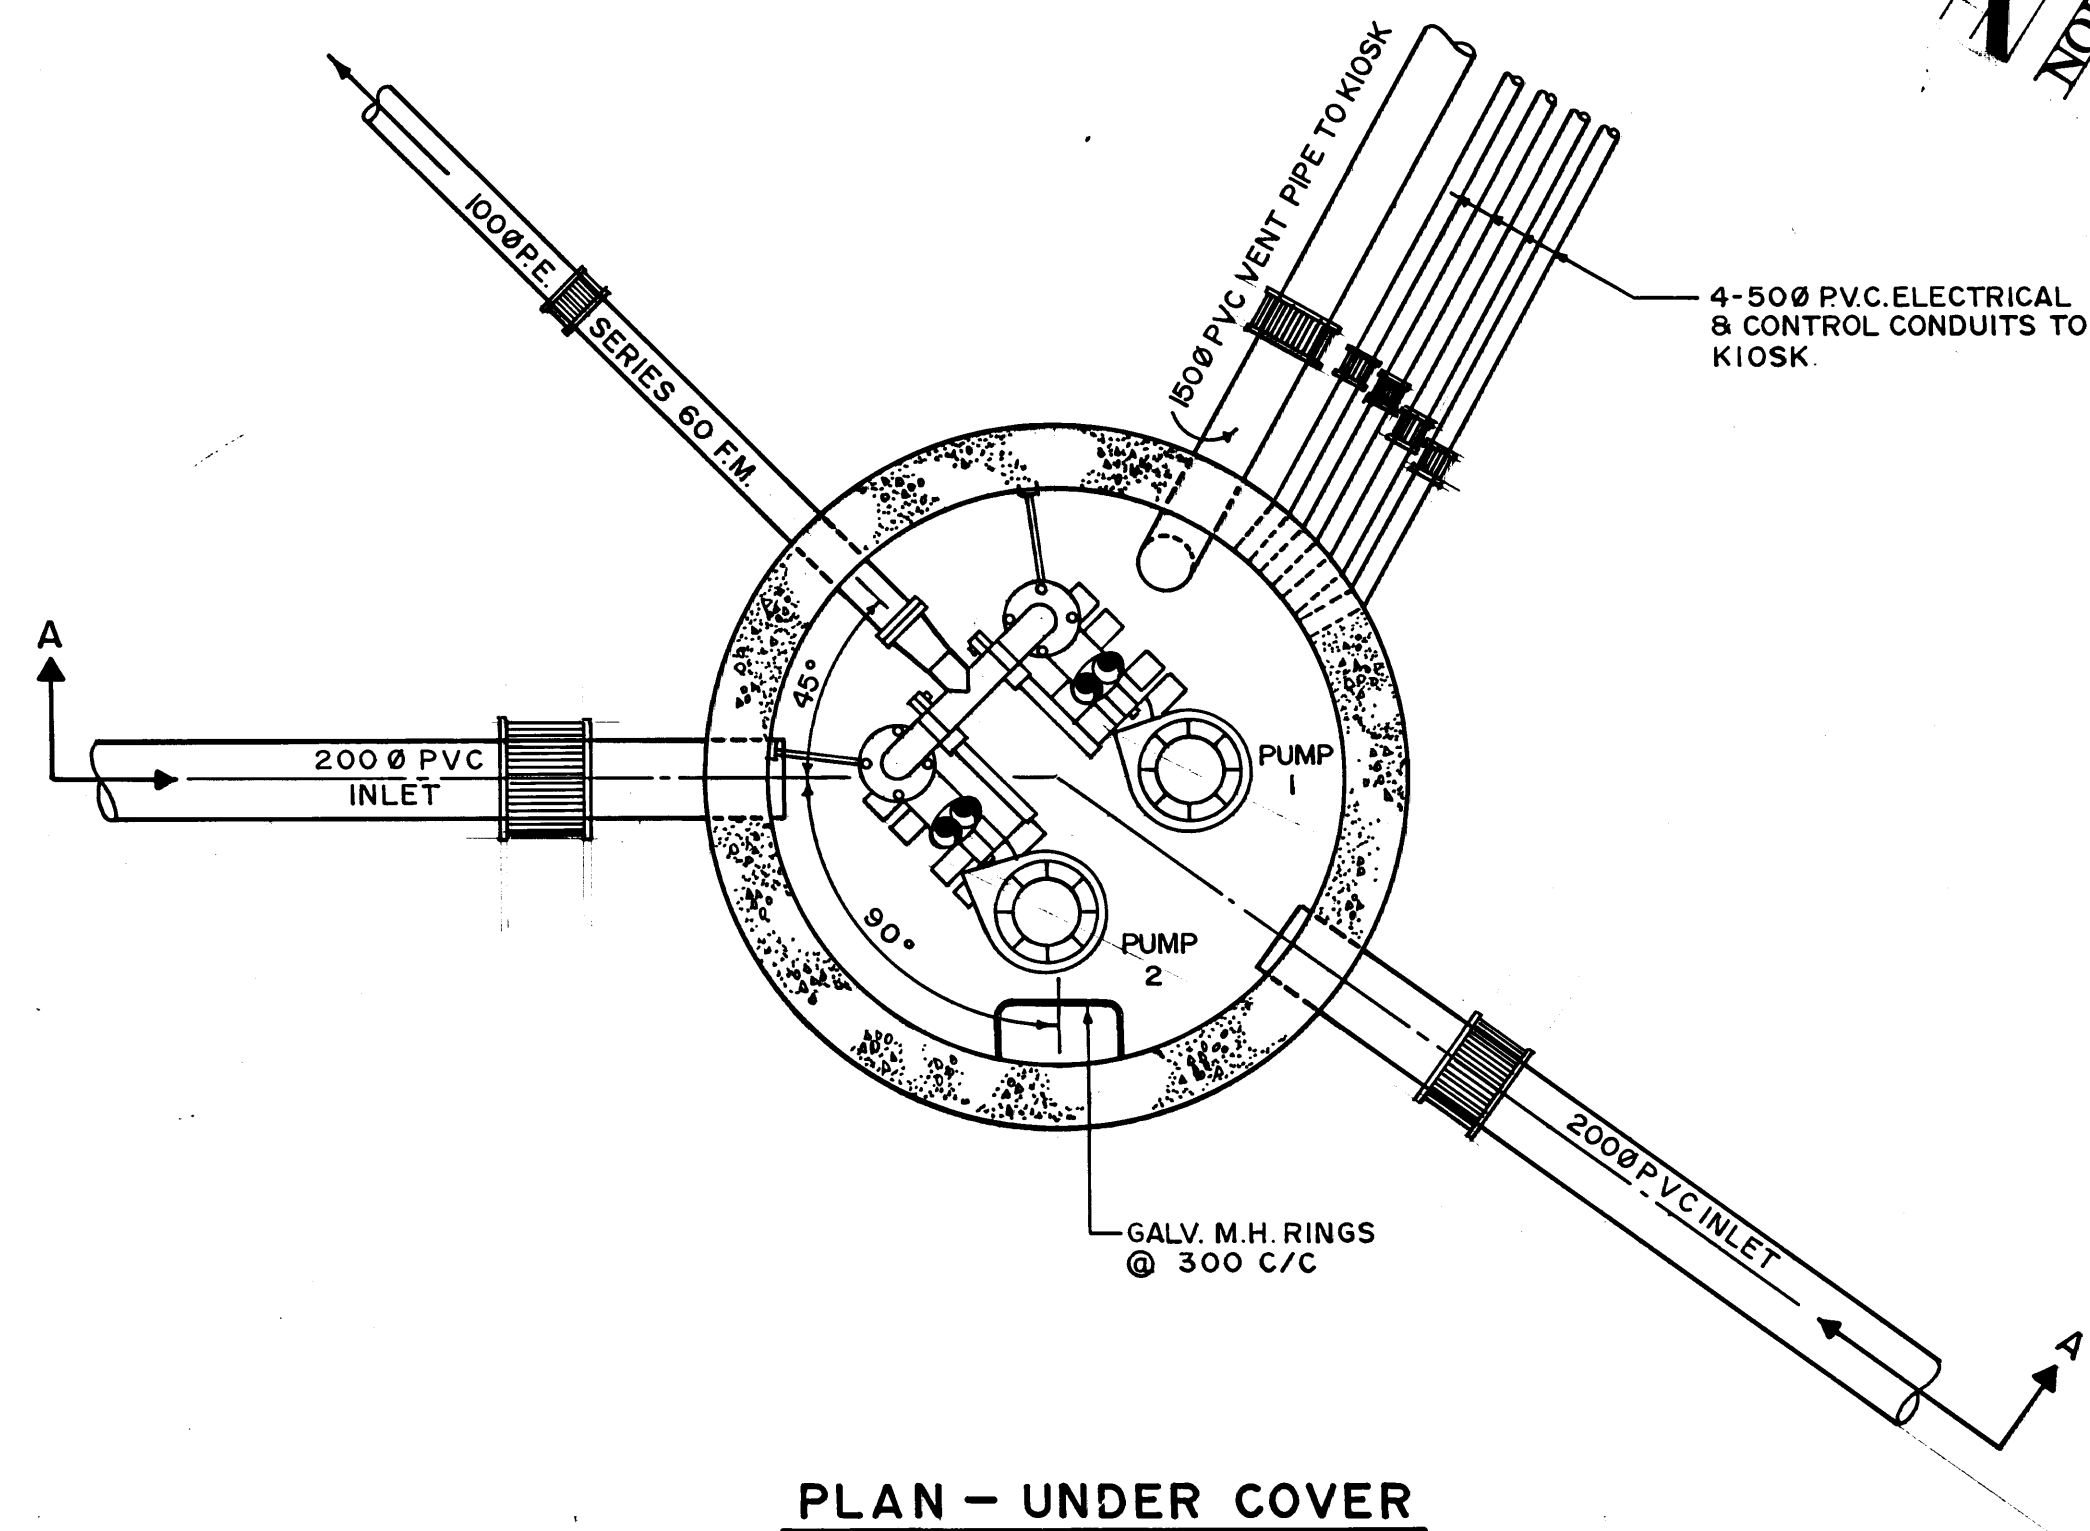
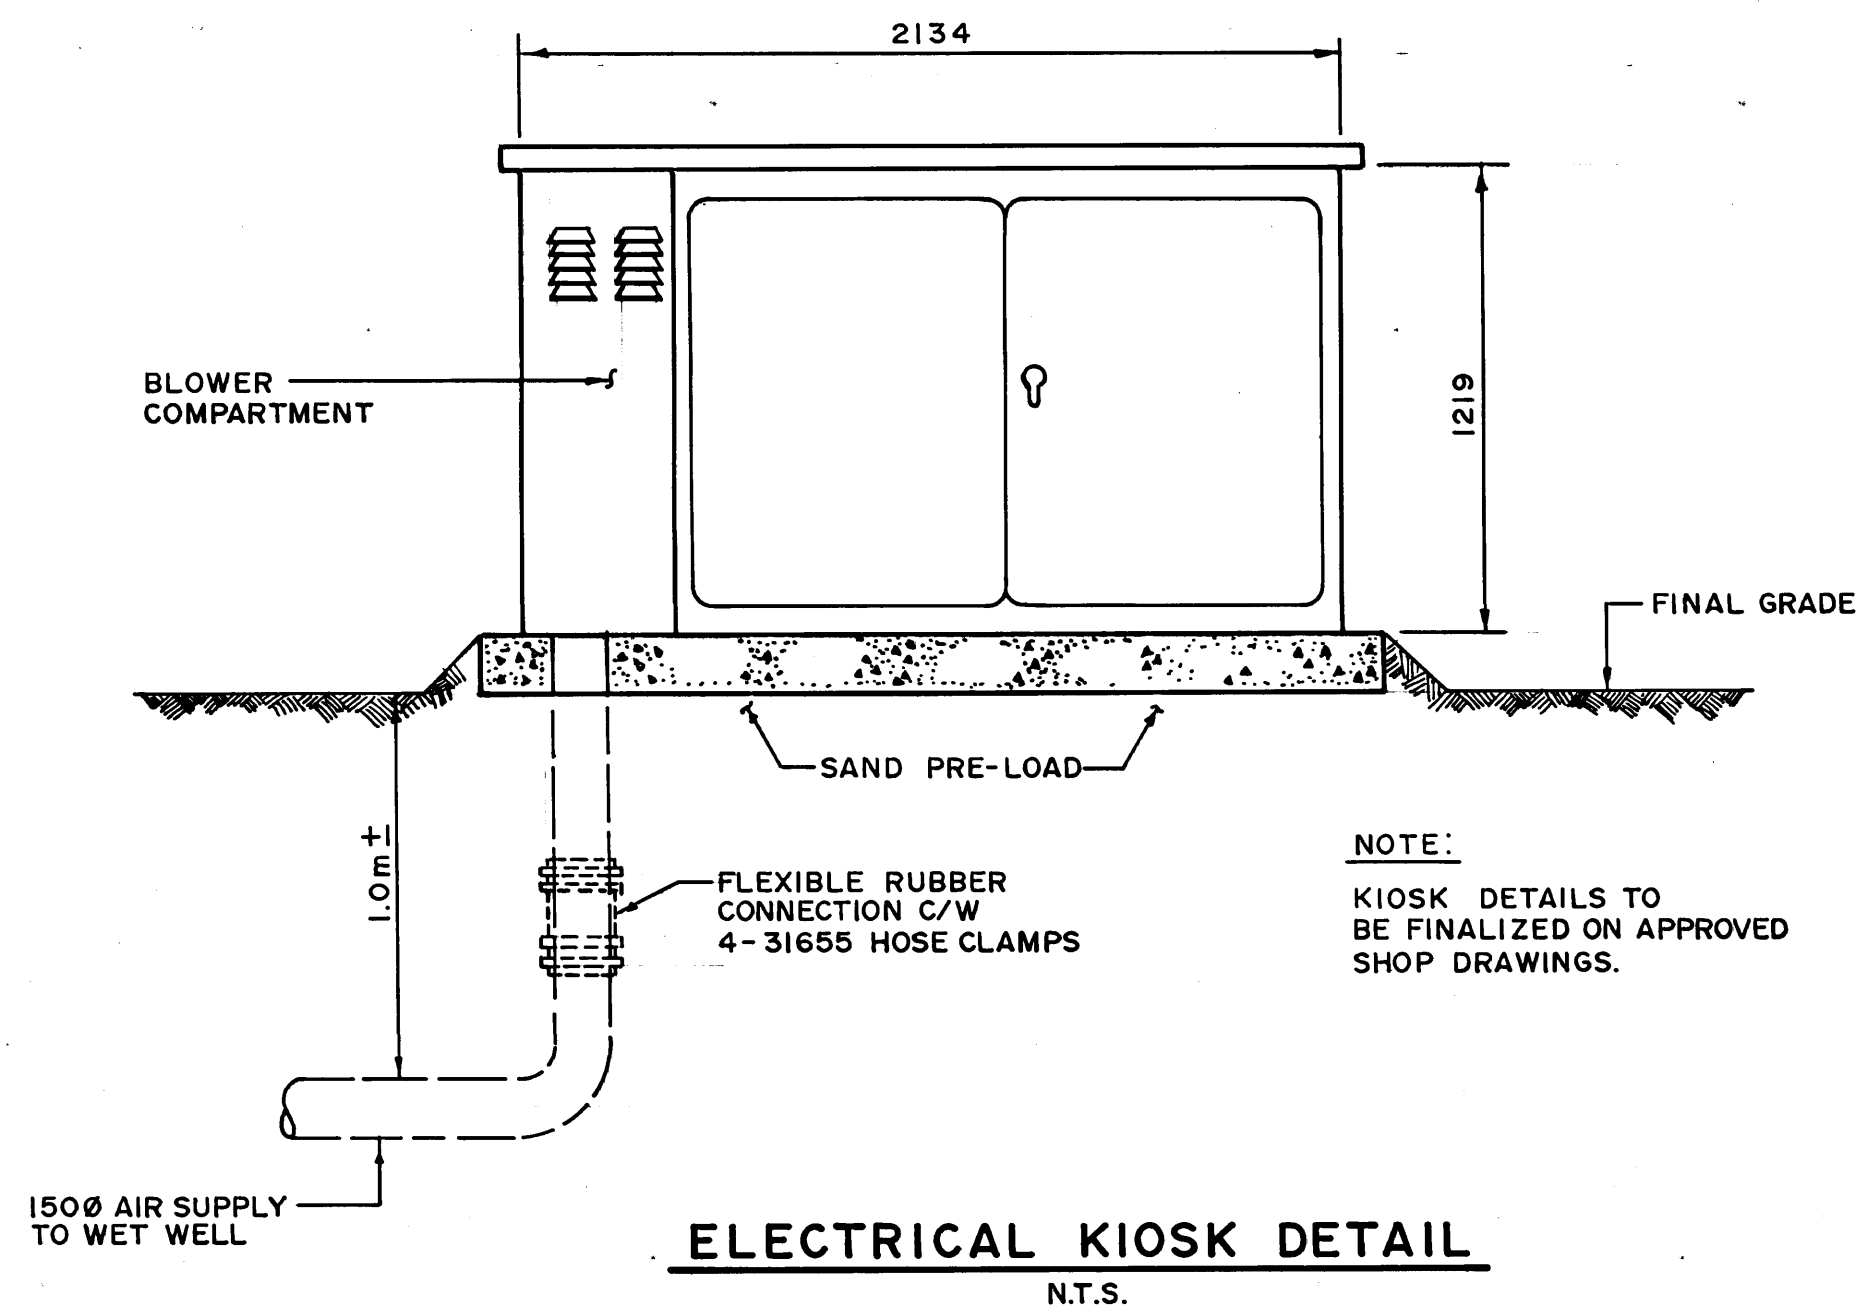
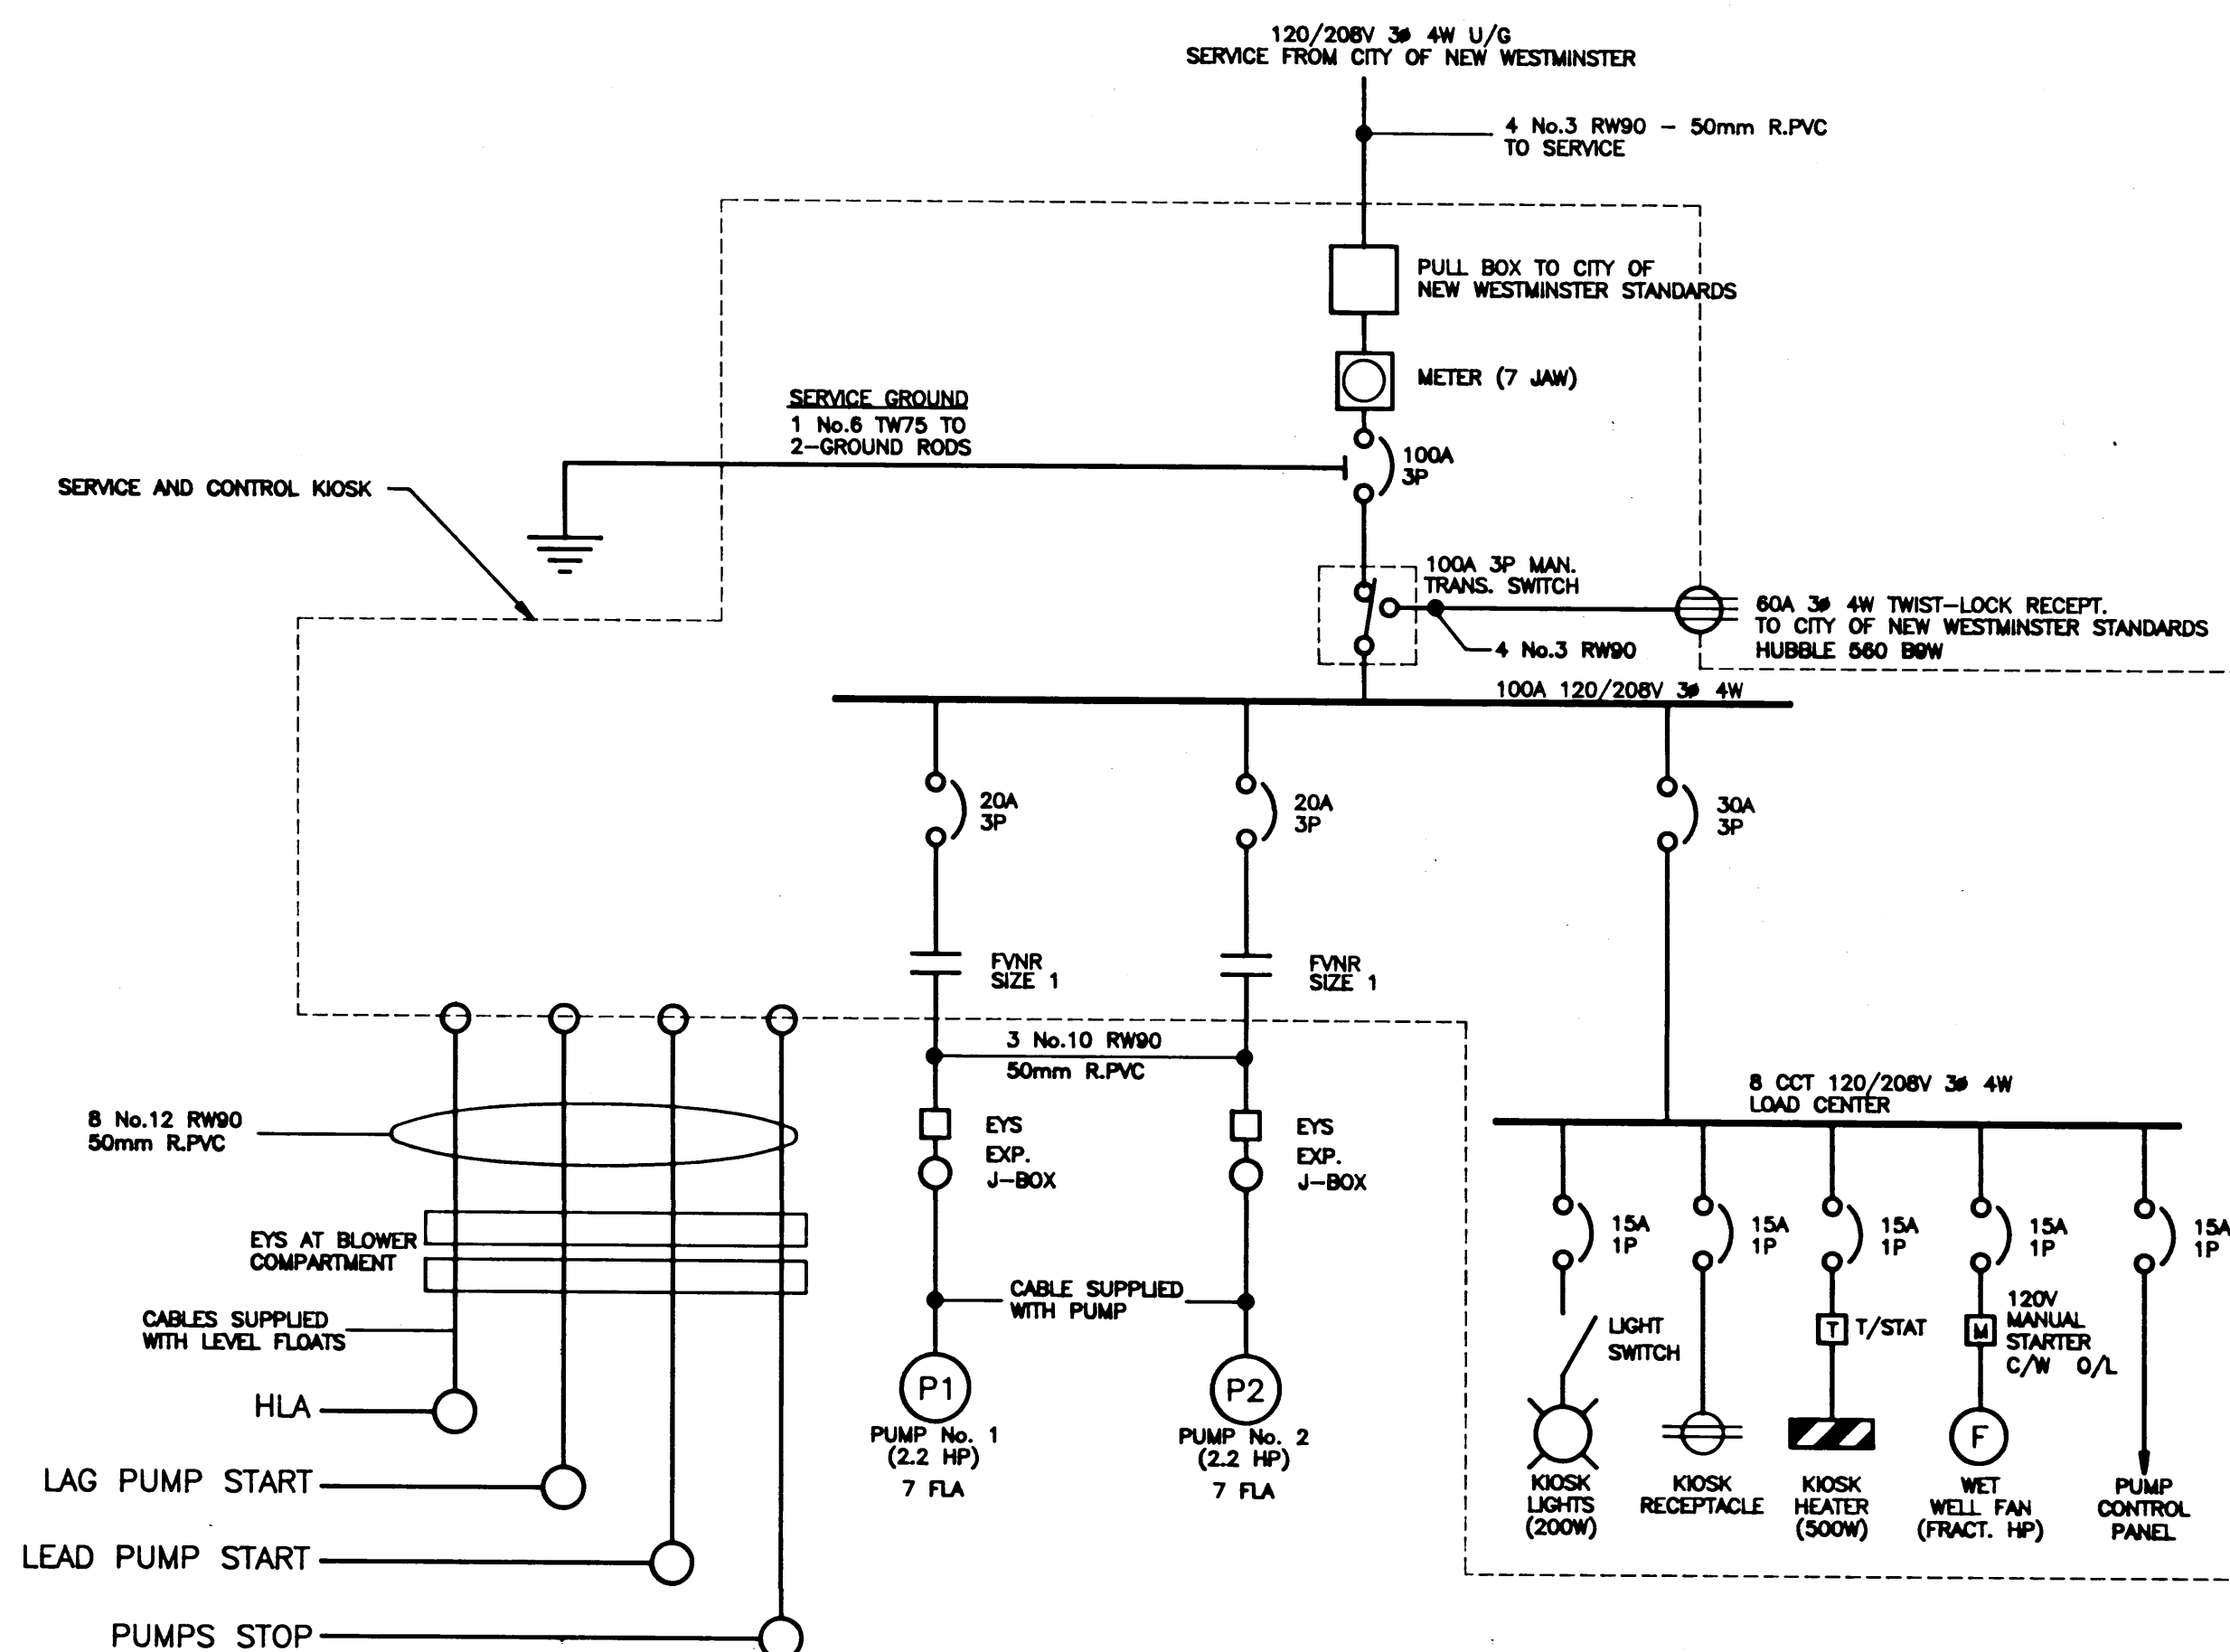
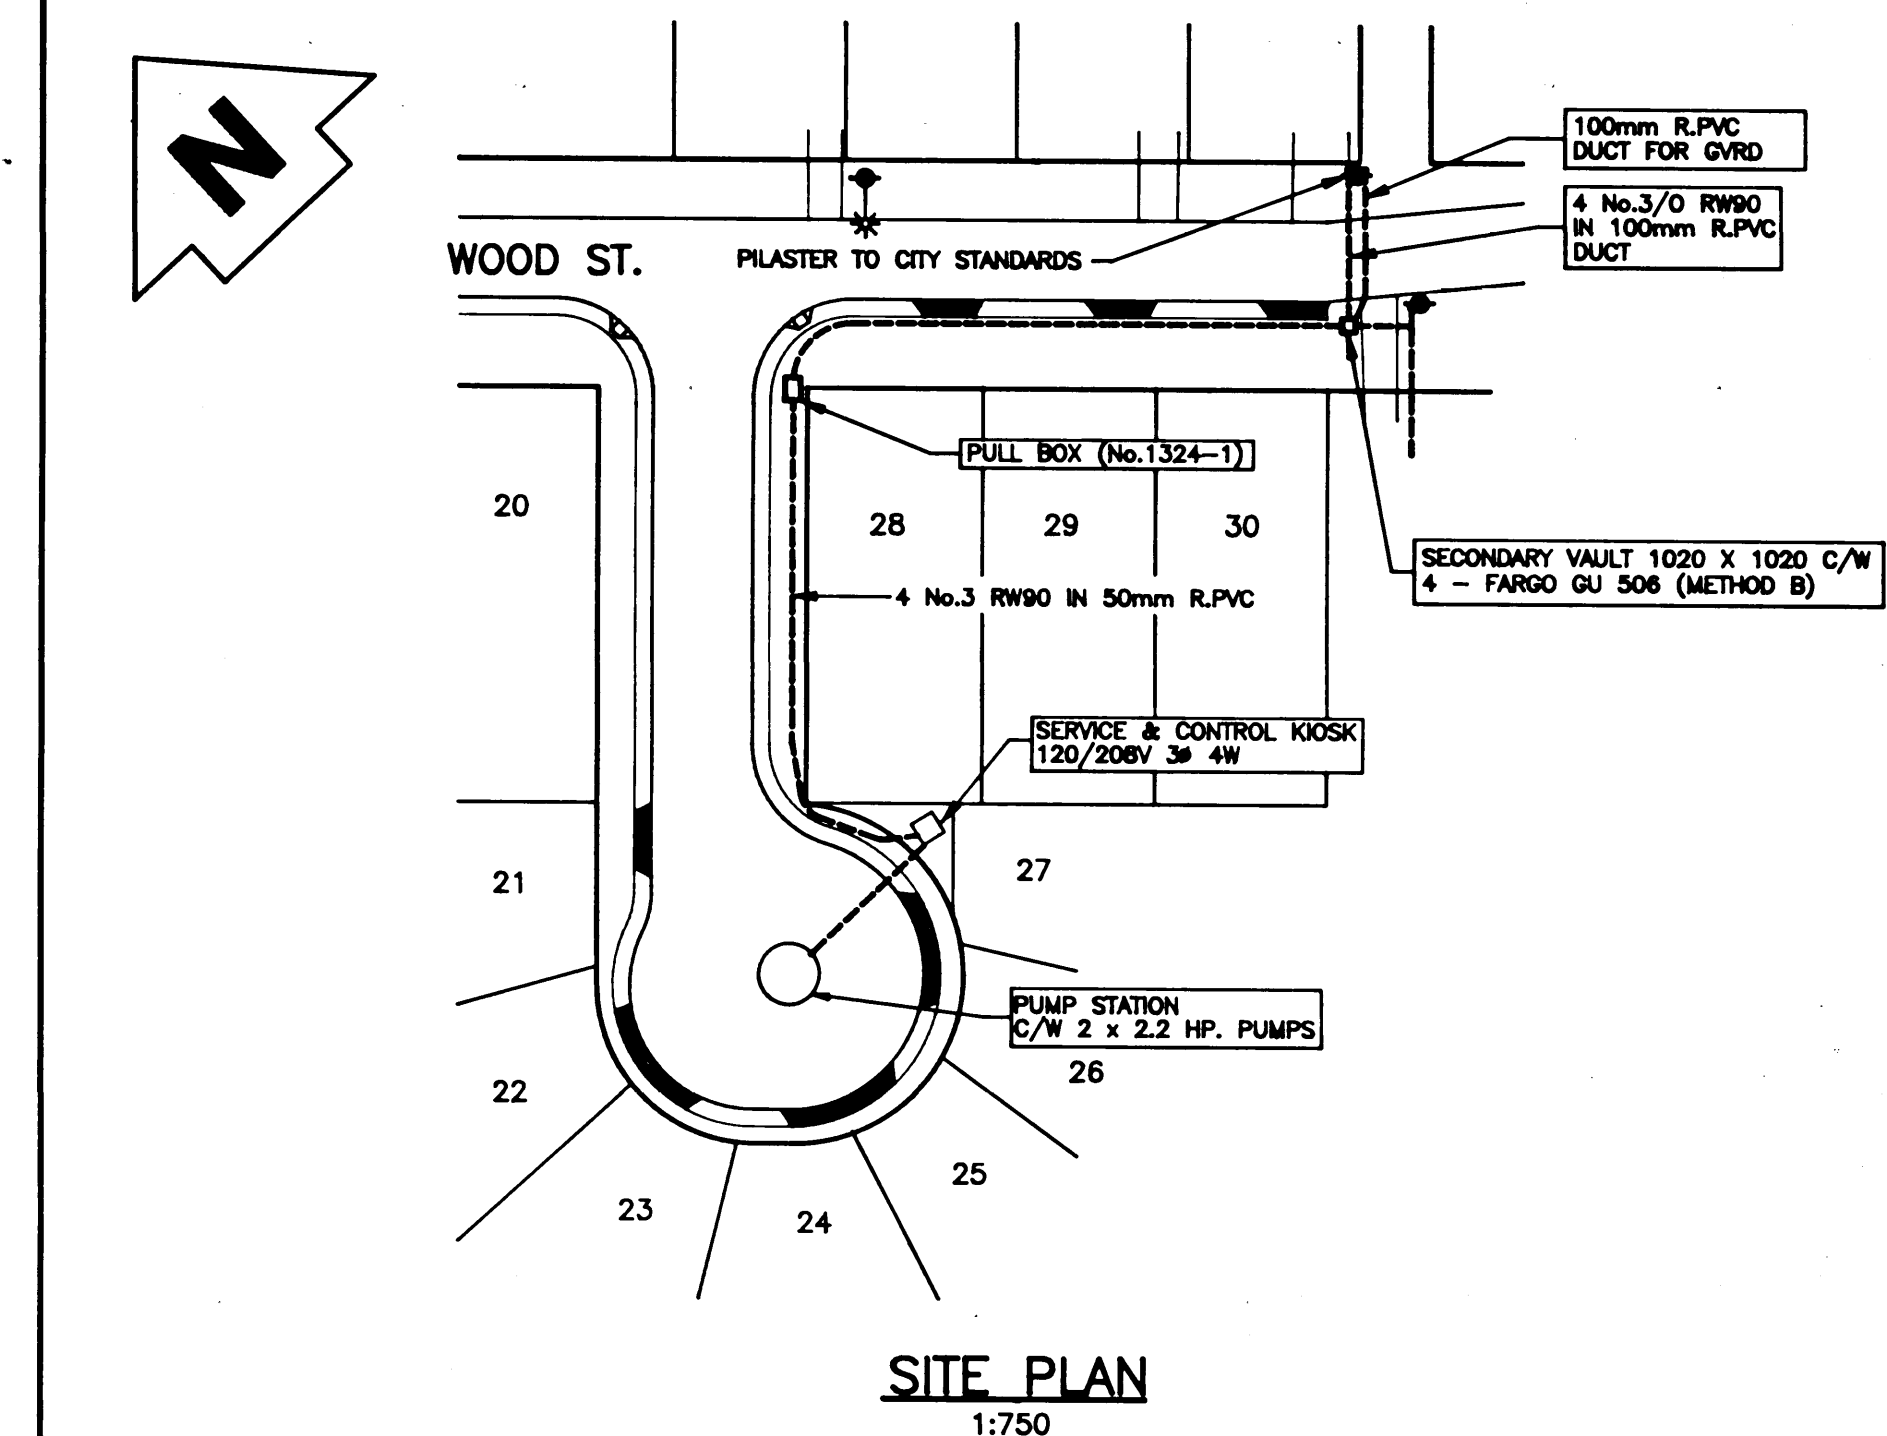
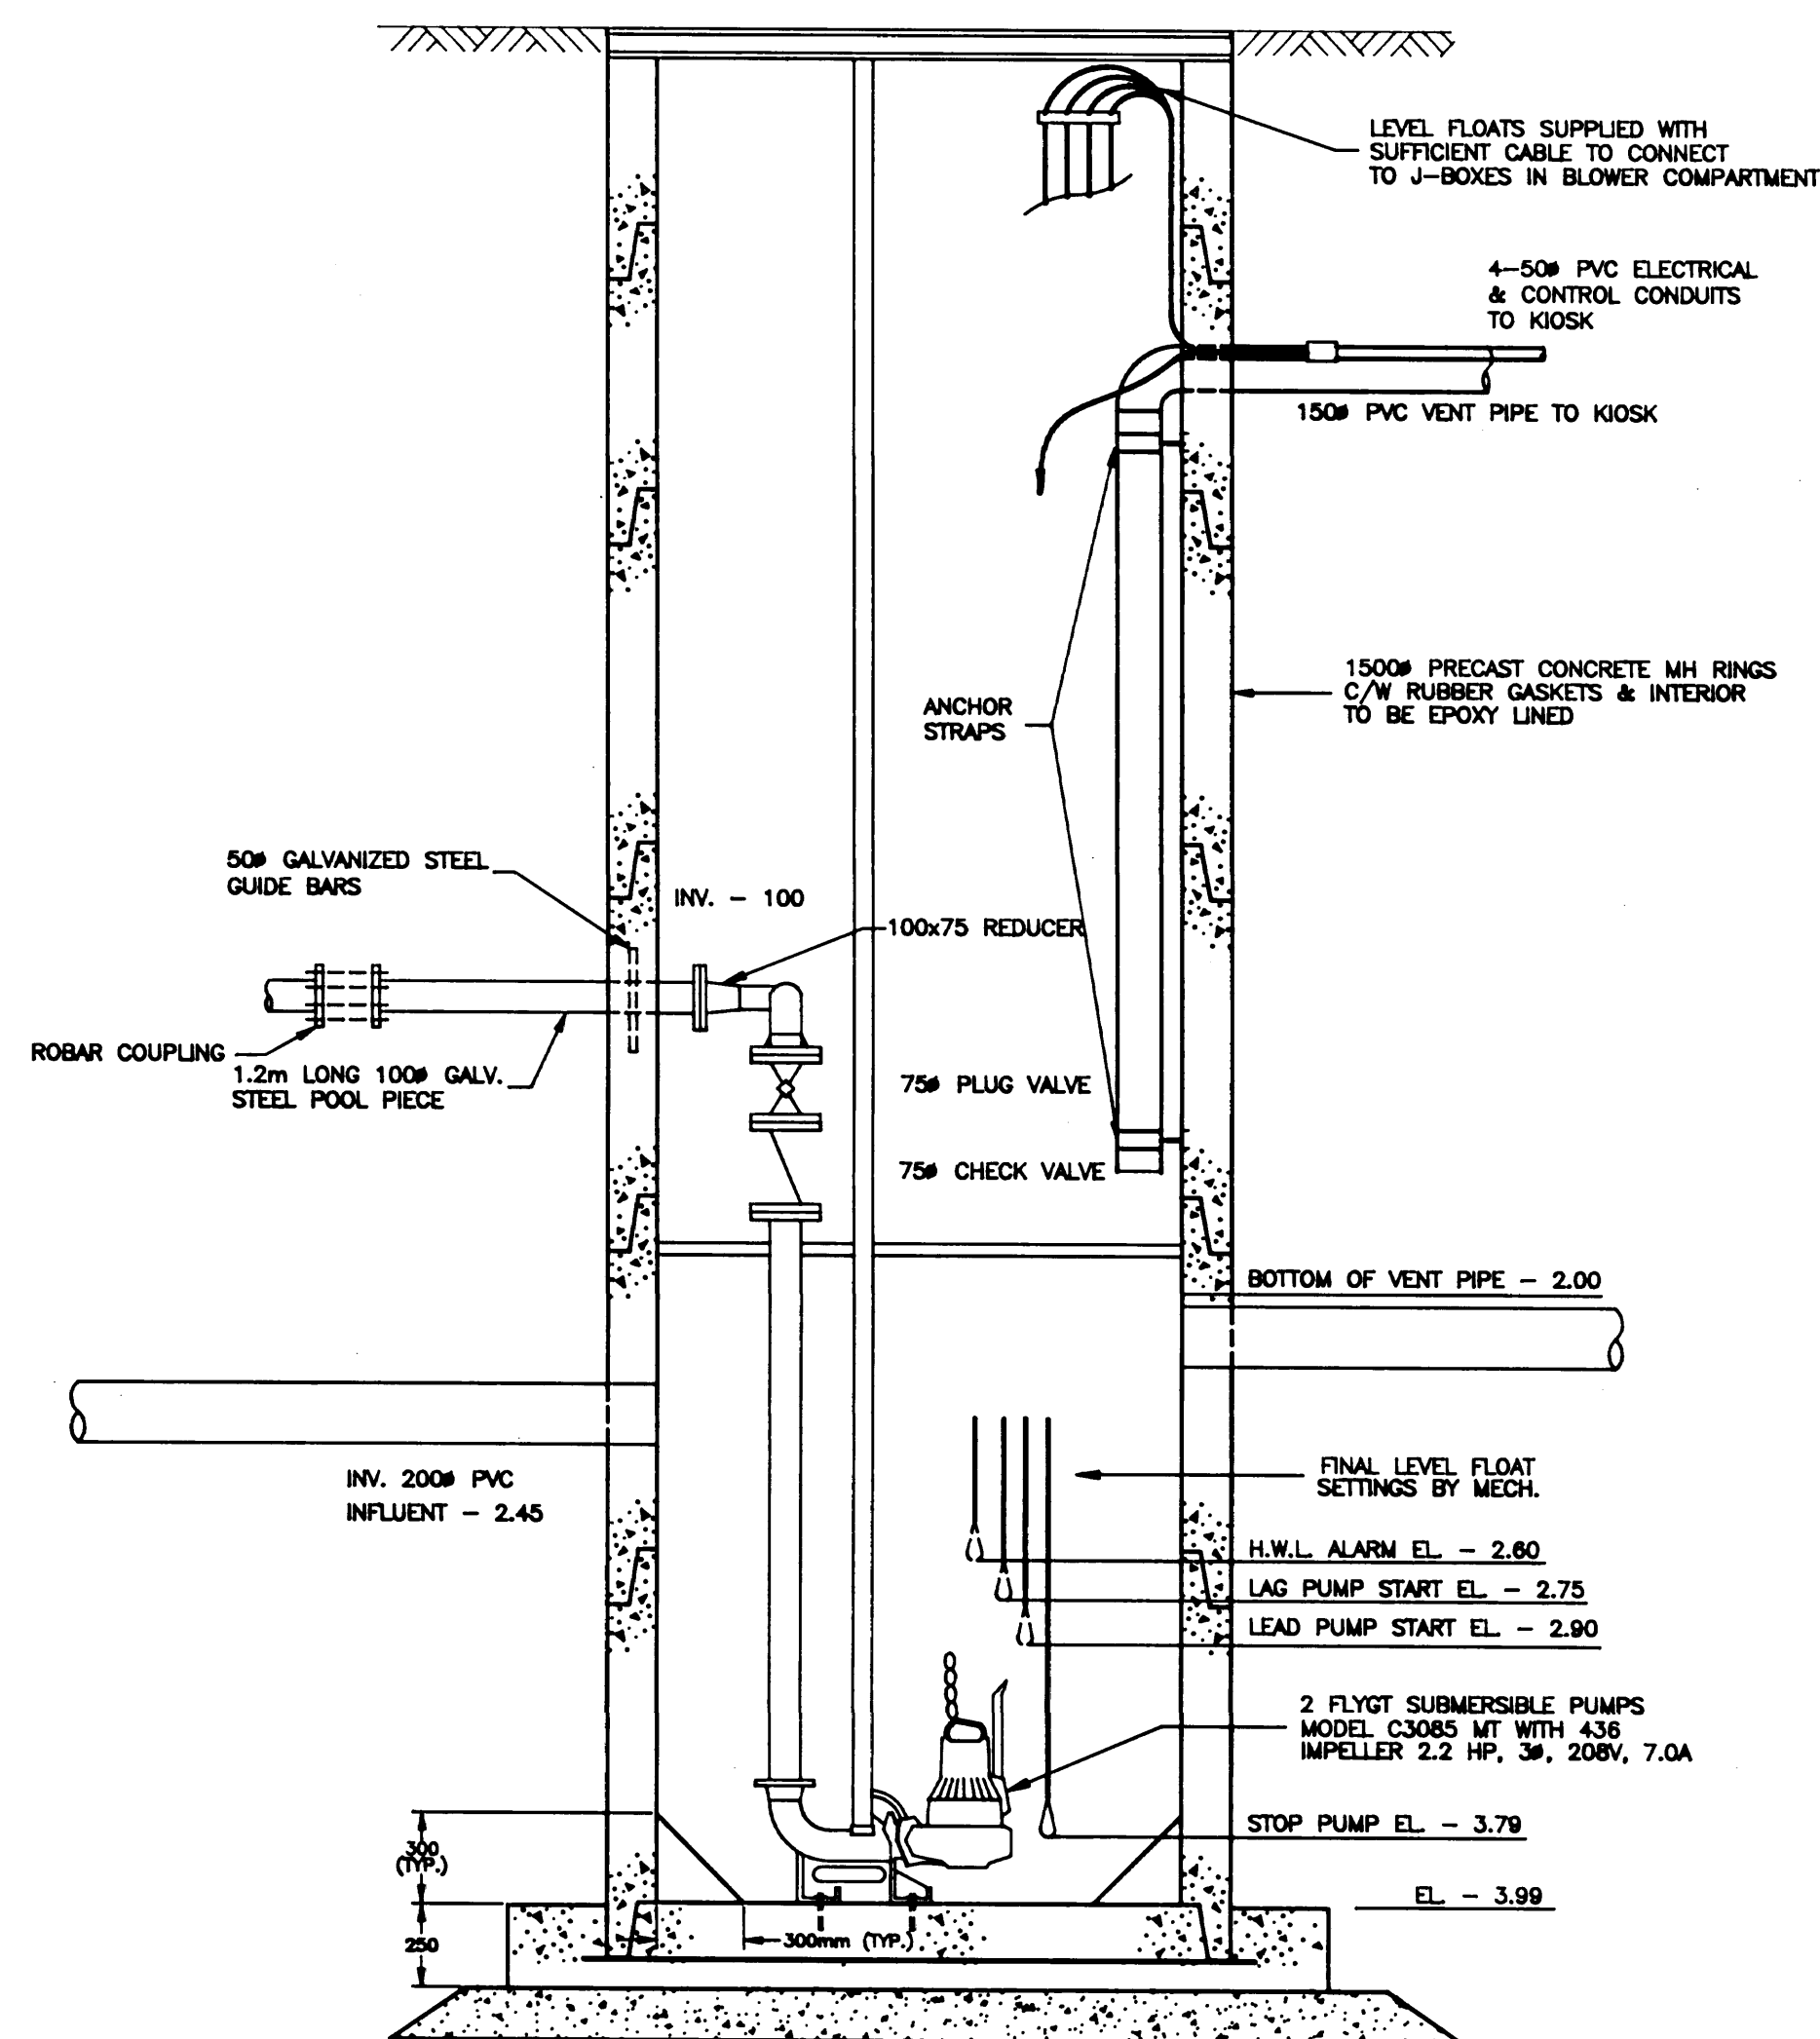
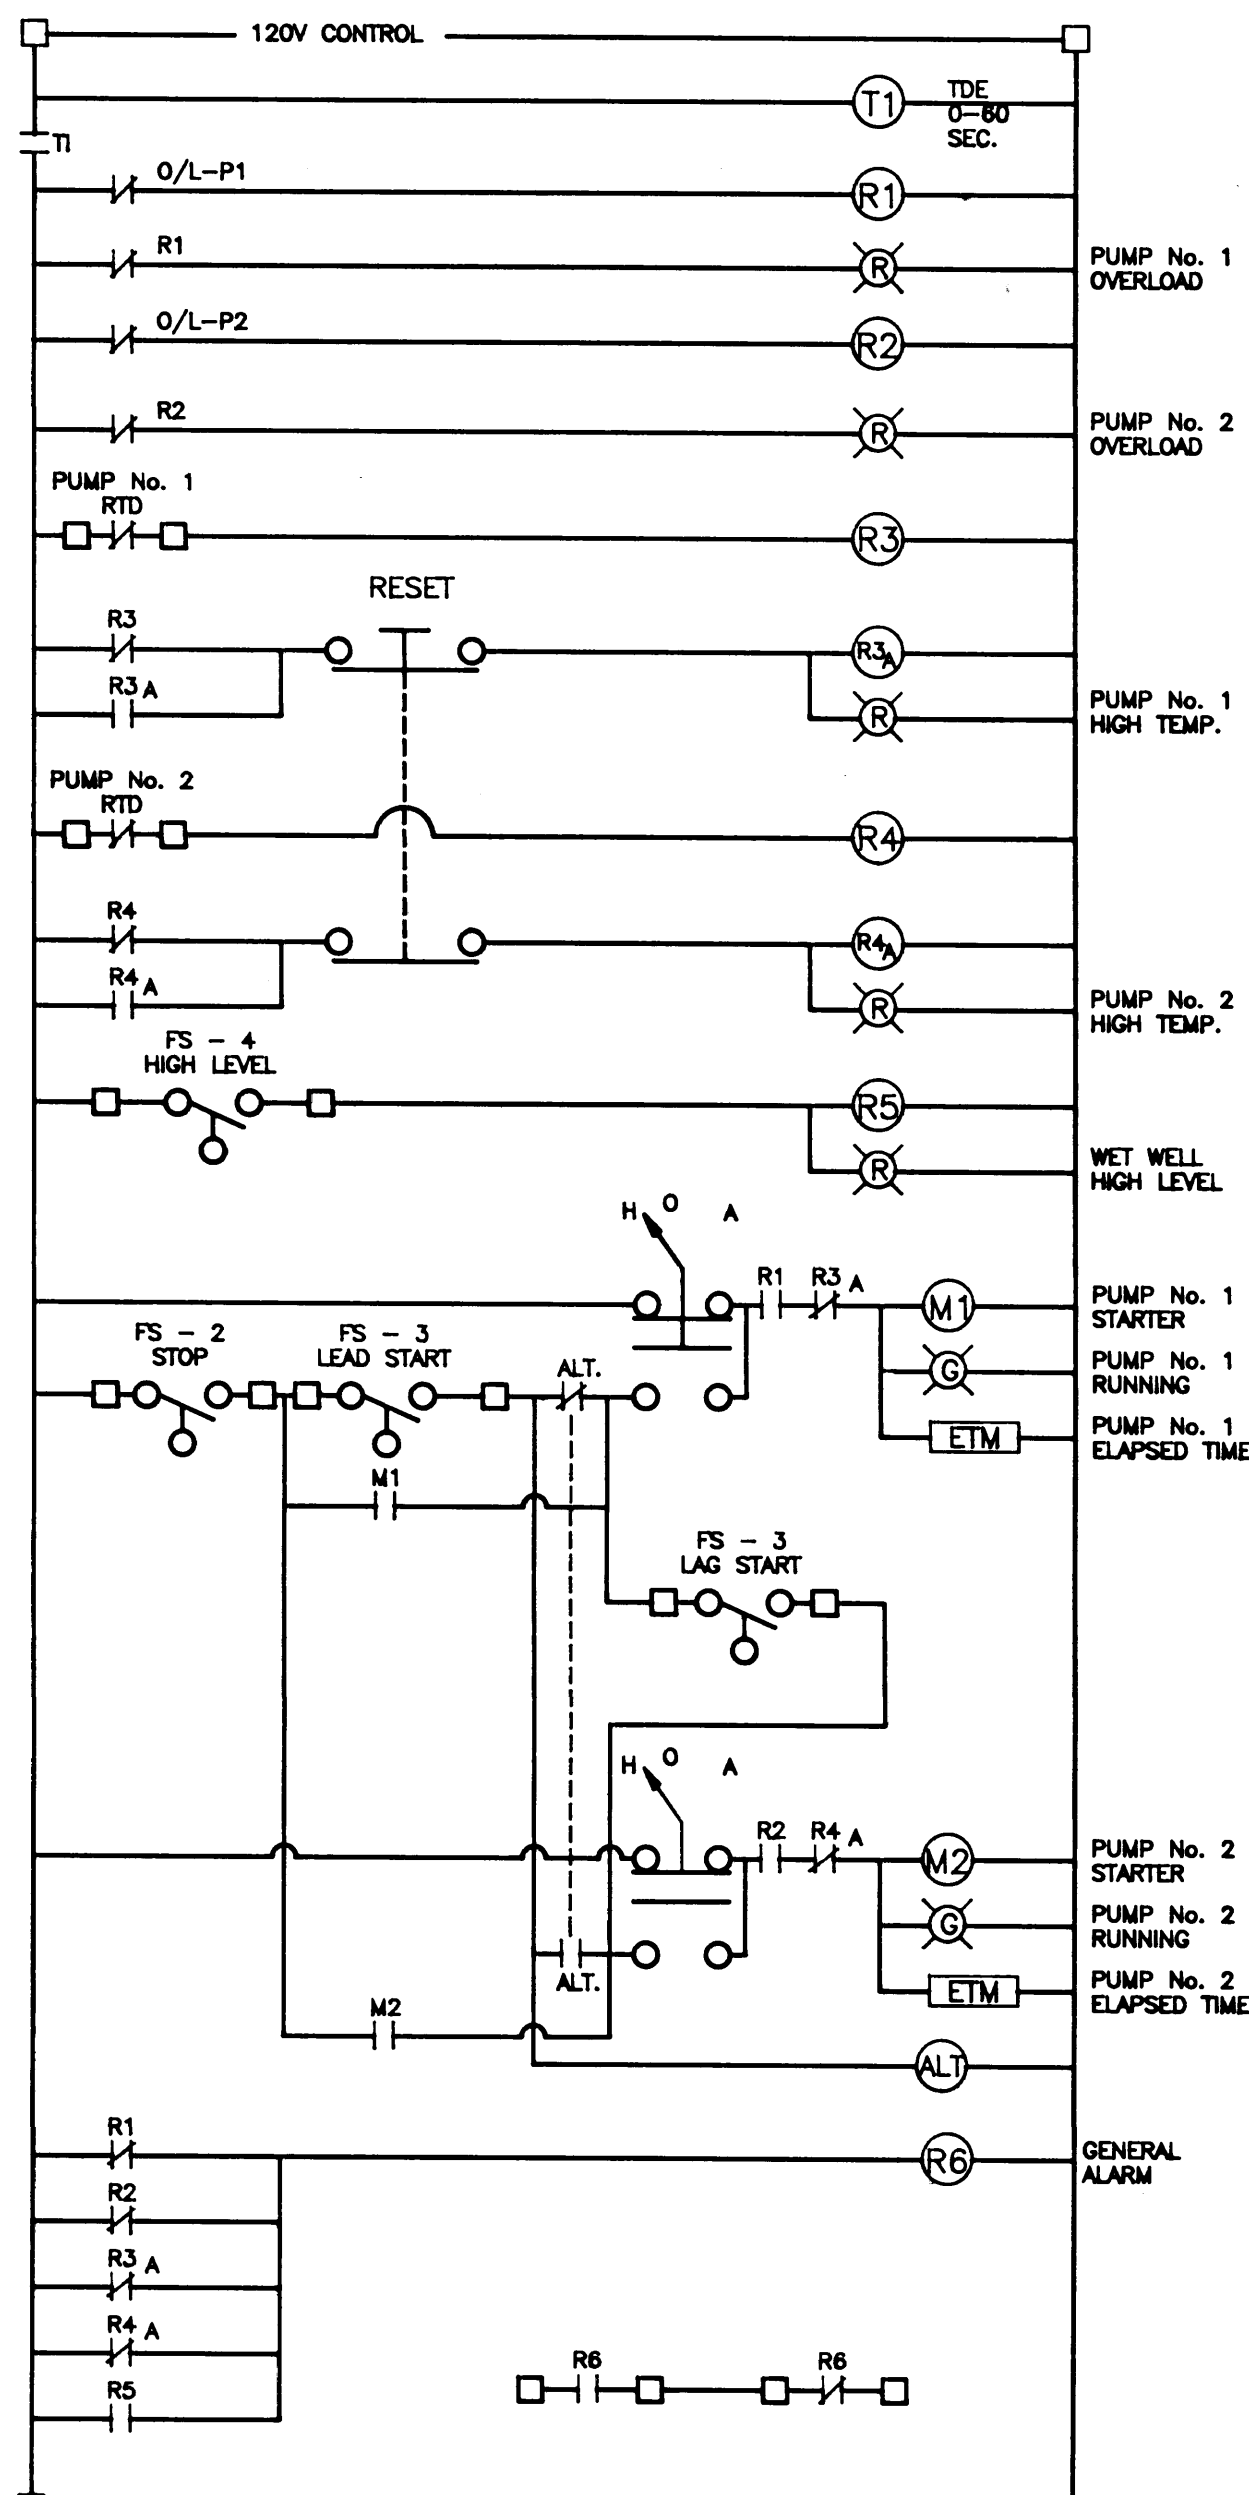


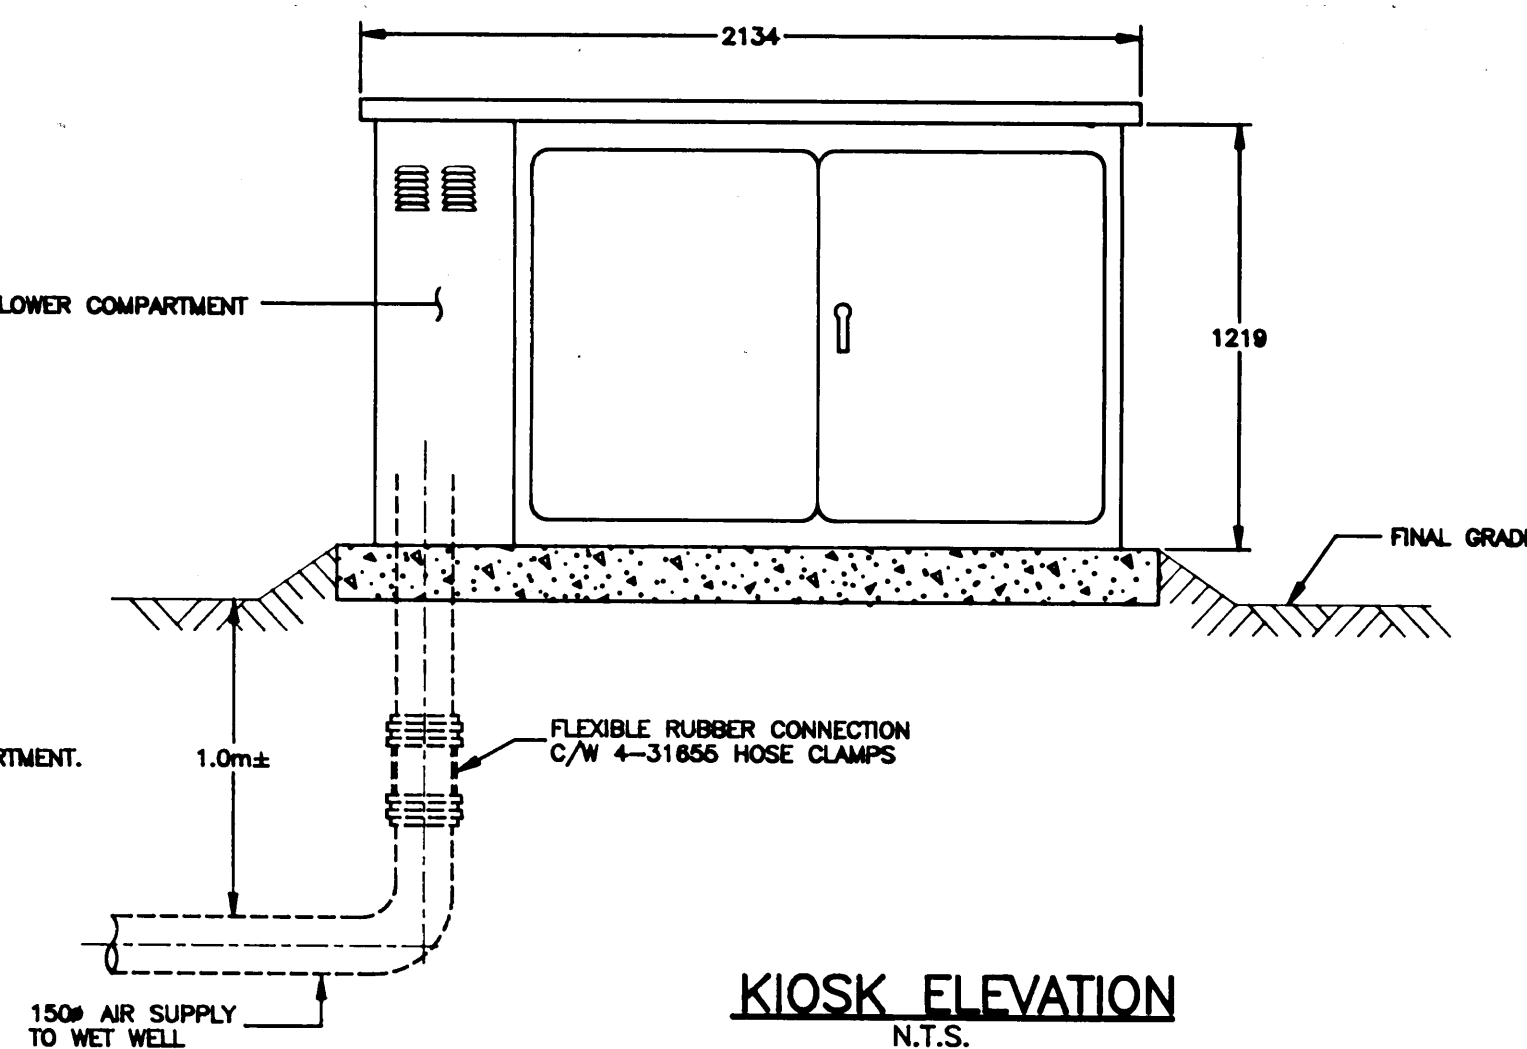

Bench Mark All elevations are geodetic & refer to mon. no. at intersection of	1	91-06-19	SANITARY LIFT STATION REVISED.	M.C.	Design	M.C.	Scale 1:20	Seal	IMC Consulting Group Inc. Suite 102, 6846 King George Hwy. Surrey, B.C. Canada V3W 4Z9 Telephone (604) 591-6171 Fax (604) 591-1856	Developer SANSO MANAGEMENT LTD. 12900 MITCHELL ROAD, RICHMOND, B.C. V6V 1M8 TEL. 644-9970 SANITARY LIFT STATION PLAN, DETAIL & SECTION	Municipal Project No. S-15-103	Drawing No. SI-0149	REV. 3
	2	91-07-23	H2O CERTIFICATION NOTE ADDED	B.T. M.C.	Drawn								
	3	91-09-17	BASE OF LIFT STA. LOWERED TO SUIT LOWERING OF SAN SEWER	M.C.	Checked								
					Approved								
Elevation	No.	Date	Revision	Dr.	Ch.	Legal File No. 90-1402						Sheet 17 of 21	

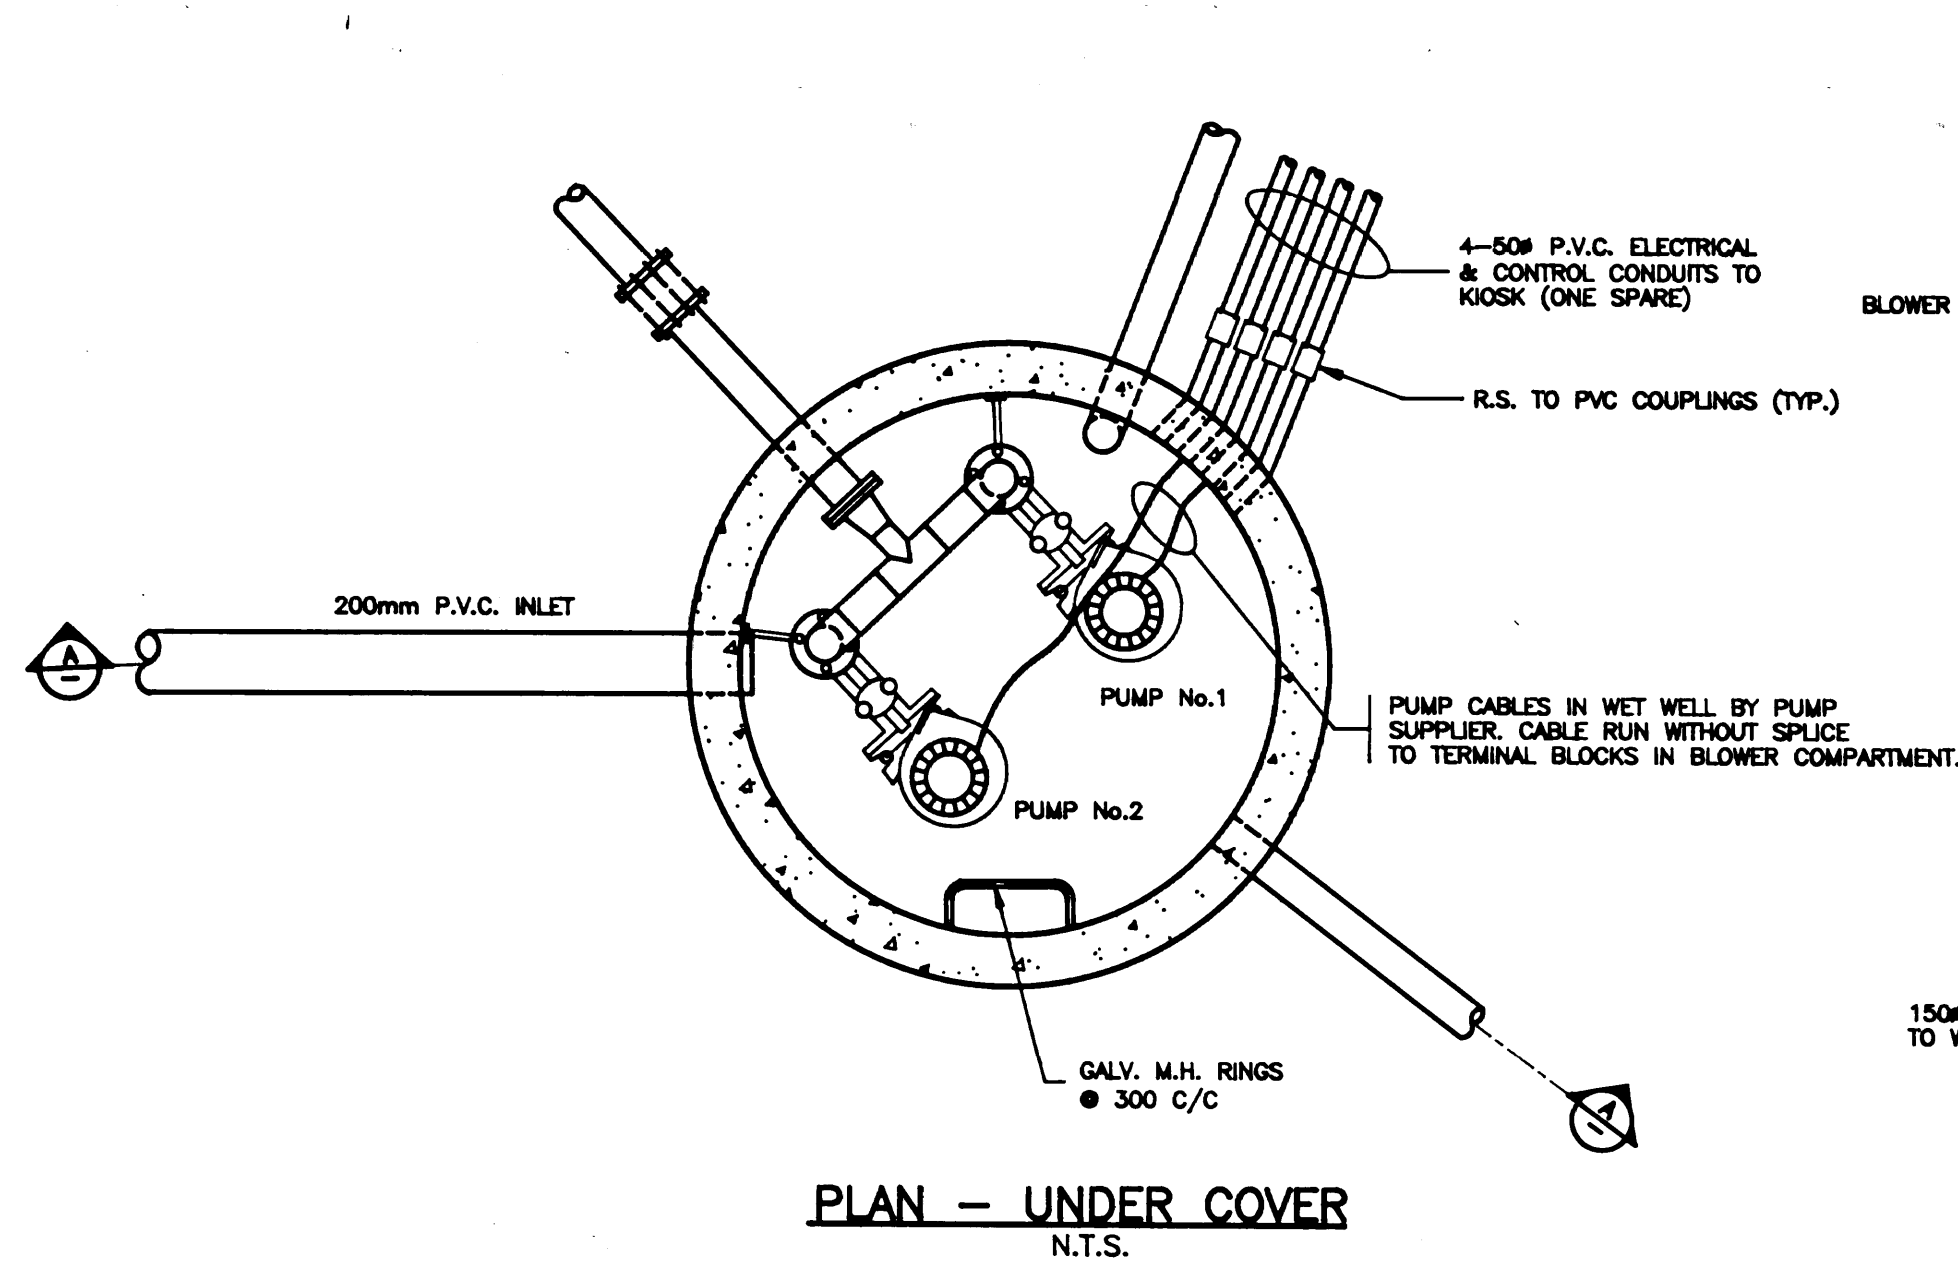


NOTES

- PROVIDE PILASTER AT CITY OF NEW WESTMINSTER SERVICE POLE AND RUN SERVICE DUCT & CABLE UP POLE TO LOCATION AS REQUIRED BY ELECTRICAL DEPARTMENT.
- ALL U/G DUCT ROUTINGS AND ELEVATIONS TO BE CONFIRMED BY ENGINEER PRIOR TO START OF CONSTRUCTION.
- KIOSK TO BE MINIMUM 12 GA STEEL, RATED EEMAC 3, C/W ALL EQUIPMENT AS PER SINGLE LINE DIAGRAM.
- CONTRACTOR TO SUBMIT KIOSK MANUFACTURE SHOP DRAWINGS FOR APPROVAL OF LAYOUT AND CONSTRUCTION PRIOR TO START OF KIOSK MANUFACTURE.

No.	DATE	Revision	Dr.	Ch.
C	92-06-22	RECORD DRAWING	S.W.	
B	91-07-08	AS REQUESTED BY CITY OF NEW WESTMINSTER	R.A.C.	R.S.
A	91-06-12	AS REQUESTED BY CITY OF NEW WESTMINSTER	D.H.	R.S.

R.P. SHAFLIK ENGINEERING LTD.
ELECTRICAL CONSULTANTS

7544 EDMONDS ST., BURNABY, B.C. V3N 1B4 TEL. (604) 526-2494 FAX. (604) 526-6901

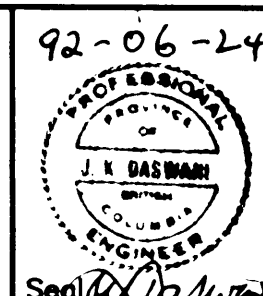


Designed	R.P.S.	Scale	AS SHOWN
Drawn	R.C.	Date	91-02-26
Checked		Client Job No.	
Approved		Drawing No. E-4799-A1-3/3	Rev. C

SANSO MANAGEMENT Ltd.

IMC CONSULTING GROUP INC.
SUITE 102, 6846 KING GEORGE HWY., SURREY, B.C.

**WOOD ST. SUBDIVISION
PUMP STATION DETAILS**
NEW WESTMINSTER

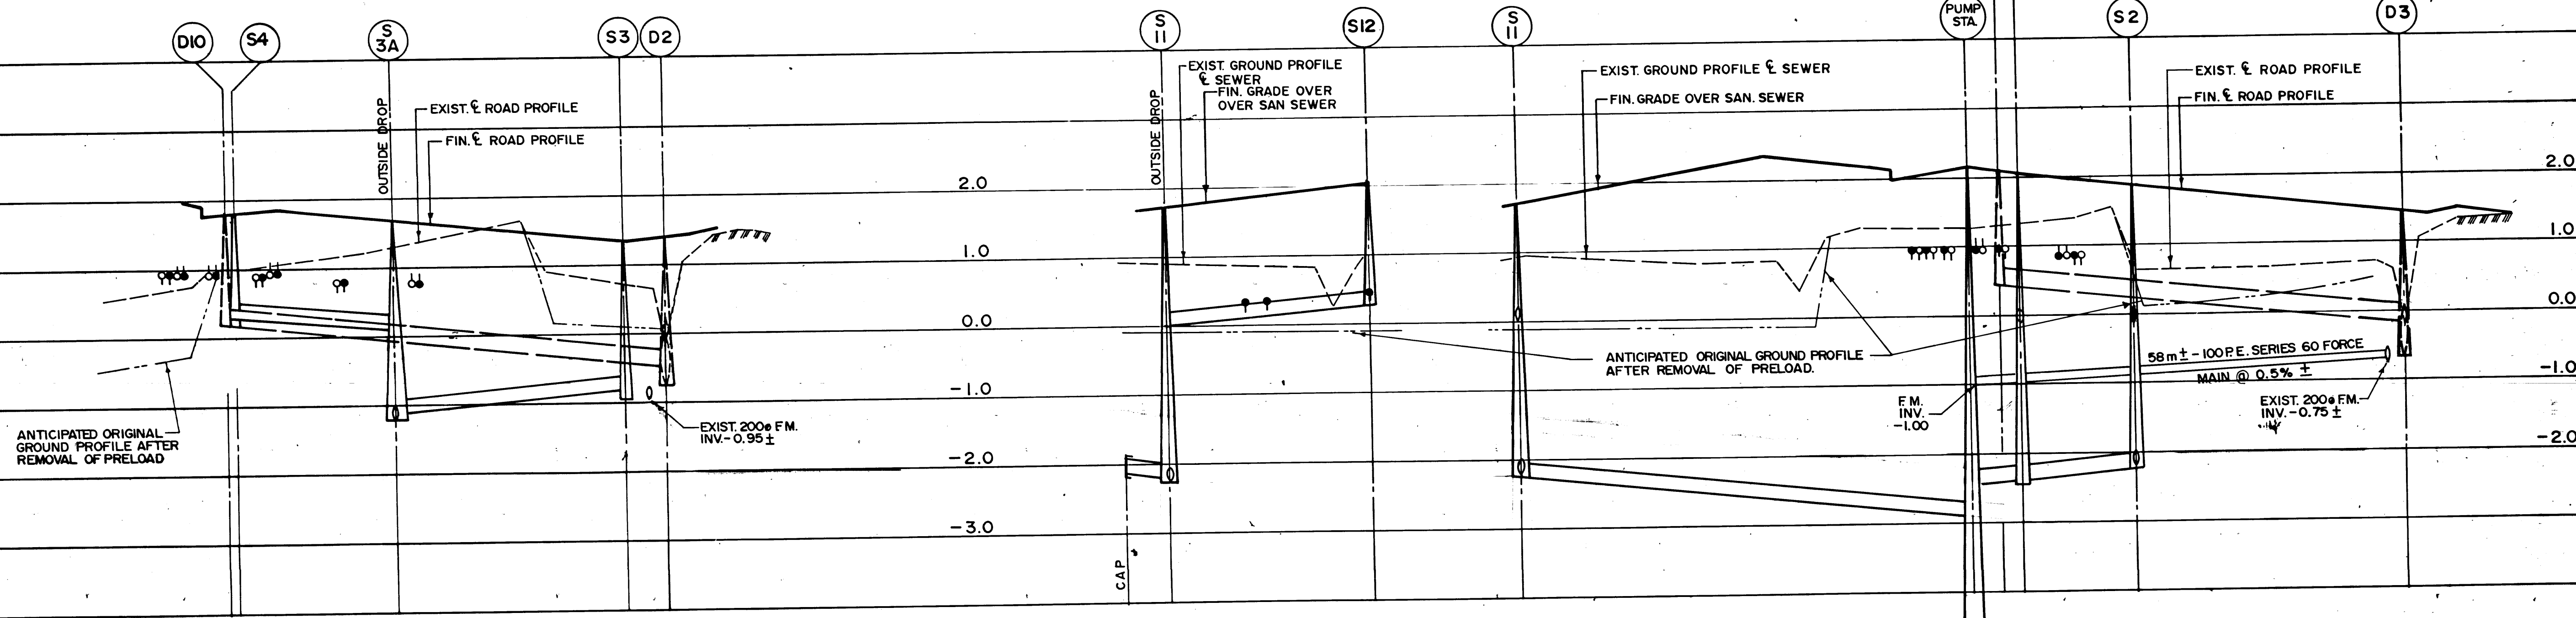[illegible][illegible]